



LEGEND:		
<u>FEATURE</u>	<u>EXISTING</u>	PROPOSED
FIRE HYDRANT MANHOLE/CATCHBASIN MANHOLE CATCHBASIN WATER VALVE LIGHT STANDARD	* *	<b>O X</b> •
DRIVEWAY (BY HOME OWNER)		
LANDSCAPING		+ + + +
PROPERTY LINE RIGHT OF WAY CONC. CURB FENCE (CHAINLINK) FENCE (WOOD) SIGN LOCATION		
BOULEVARD TREE LOCATION SANITARY RISER UTILITY LOT BARRIER PARK BENCH GARBAGE BIN		© ®

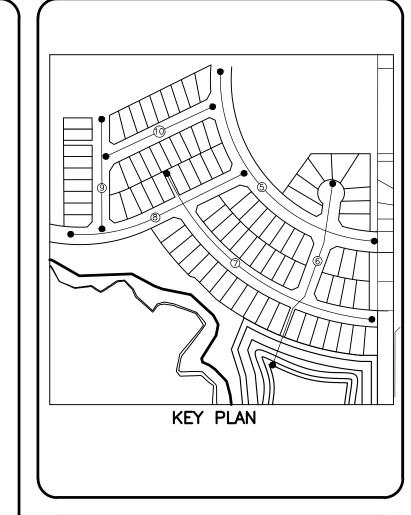

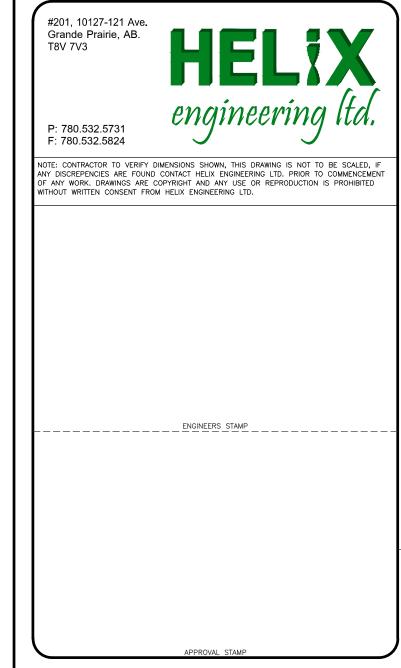

DESC.	DATE		
	DAIL	BY	APP
AQUATERA COMMENTS	27/03/13	CMS	SRI
CITY AND AQUATERA COMMENTS	29/05/13	MAB	SRI
CITY AND AQUATERA COMMENTS	18/06/13	MAB	SRI

272649 ALBERTA LTD.

O'BRIEN LAKE WEST PHASE 1

FENCE LOCATION PLAN

LOCATION:
FLYING SHOT LAKE SETTLEMENT
LOT 11A, BLK 1, PLAN 062— 1428

DESIGN:	CMS	DRAWN:		CHK'D:	SRF
DATE:	JAN	16/13 BM:		ASCM	XXXXX
		SCALE 1:750			
	10 5	0 5 10	20	30	
DRAWING:					
DRAWING:		09-00	5_[	טר	
	<u> </u>	09-00	/J—I	<i></i>	
PAGE:					
	4			4 0	
	7				